

**DRAWING INDEX**

- SD1 SITE PLAN
- SD1-L SITE LIGHTING PHOTOMETRIC
- G1 BOUNDARY & TOPOGRAPHIC SURVEY
- 1 OF 3 PRELIMINARY GRADING PLAN
- 2 OF 3 COMPOSITE UTILITY PLAN
- 3 OF 3 STORMWATER CONTROL PLAN
- LA1 LANDSCAPE PLAN
- LA2 CITY ARBORIST NOTES & TREE PROTECTION DETAIL
- SD2 NEIGHBORHOOD CONTEXT
- SD9 SITE DETAILS
- AI0 EXISTING FLOOR PLAN
- AU1 PROPOSED CONVENIENCE STORE & CARWASH FLOOR PLANS
- A21 PROPOSED EXTERIOR ELEVATIONS
- A22 PROPOSED EXTERIOR ELEVATIONS
- CA1 CANOPY ELEVATIONS

**SITE INFORMATION**

APN: 220-18-002  
 JURISDICTION: SANTA CLARA, CA  
 CURRENT ZONING: (ON NEIGHBORHOOD COMMERCIAL)

**SITE AREA:** 10,544 SF. (0.426 AC)

**TOTAL LANDSCAPE AREA:**

- (N) LANDSCAPE: 3,486 SF. (0.83 N)
- (N) LANDSCAPE: 5,050 SF. (21.23 N)
- (N) CONVENIENCE STORE: 1,602 SF.
- (N) CARWASH TUNNEL: 642 SF.
- (N) CARWASH EQUIPMENT ROOM: 244 SF.
- (N) FUELING CANOPY: 2,556 SF.
- (E) BUILDING UNDER CANOPY TO BE DEMOLISHED: 1,502 SF.
- (E) FUELING CANOPY TO BE DEMOLISHED: 5,044 SF.

**PARKING REQUIREMENTS:**

**CONVENIENCE STORE:**  
 (1 SPACE PER 200 SF) / (602 SF. / 200 = ) 3 SPACES

**PARKING REQUIRED:** 0 SPACES

**PARKING PROVIDED:**

- STANDARD PARKING STALLS (7'x15'): 1 SPACE
- VACUUM PARKING STALL (8'x10'): 1 SPACE
- AIR & WATER PARKING STALL (8'x20'): 1 SPACE
- ACCESSIBLE PARKING STALL (17'x20'): 4 SPACES
- FUEL POSITIONS (8'x30'): 4 SPACES

**TOTAL PARKING PROVIDED:** 0 SPACES

**SITE PLAN LEGEND**

- NEW LANDSCAPING
- NEW CONCRETE PAVING
- 4 FT. WIDE (MIN) ACCESSIBLE ROUTE OF TRAVEL, SHALL NOT EXCEED 5% SLOPE IN THE DIRECTION OF TRAVEL AND 2% CROSS SLOPE
- BIO PLANTER, SEE CIVIL DWGS.
- EXISTING TO REMAIN
- EXISTING CURB TO REMAIN
- NEW CONCRETE CURB

**PROJECT DIRECTORY**

**ARCHITECT**  
 M I ARCHITECTS, INC.  
 1801 OAKLAND BLVD, SUITE 300  
 WALNUT CREEK, CA 94596  
 TEL: (925) 291-1114 #1  
 FAX: (925) 943-1061  
 CELL: (925) 918-9875  
 MR. MITAHNA ERKAWI, ARCHITECT

**DEVELOPER**  
 MR. SUJEET S. DAND  
 2445 LAWRENCE EXPRESSWAY  
 SANTA CLARA, CA 95050  
 TEL: (408) 694-3095 (CELL)

**CIVIL ENGINEER**  
 SUREAN CONSULTING ENGINEERS, INC.  
 1044 COLORA ROAD, SUITE 235C  
 GOLD RIVER, CA 95620  
 TEL: (916) 856-8241  
 FAX: (916) 898-6366  
 MR. FAREED T. SIDDIQUI, P.E.

**LANDSCAPE ARCHITECT**  
 GARDIELLA ASSOCIATES  
 300 CLOCK TOWER PLACE, SUITE 1100  
 GARDEN, CA 95923  
 TEL: (925) 526-6100  
 CELL: (925) 624-6100  
 MR. RICHARD GARDIELLA

**VICINITY MAP**



**M I Architects, Inc.**  
 ARCHITECTURE  
 PLANNING  
 MANAGEMENT  
 DESIGN

1801 OAKLAND BLVD  
 SUITE 300  
 WALNUT CREEK, CA  
 94596

925-287-1114 Tel  
 925-443-1591 Fax  
 925-618-9875 Cell  
 mihonam@architect.com  
 www.michitect.com

NOT FOR CONSTRUCTION

CONVENIENCE STORE & CARWASH  
 2445 LAWRENCE EXPRESSWAY  
 SANTA CLARA, CA 95051

ISSUED FOR CONSTRUCTION	
ISSUED FOR PLAN CHECK	
ISSUED FOR PERMITTING	
NO. DATE DESCRIPTION	
1	
2	
3	
4	

SITE PLAN


PROJECT NO. 22-14501  
 DRAWN BY: \_\_\_\_\_ CHECKED: M1  
 SCALE: AS NOTED DATE: 10-10-23

**SD1**

SHEET OF

**MONROE STREET**

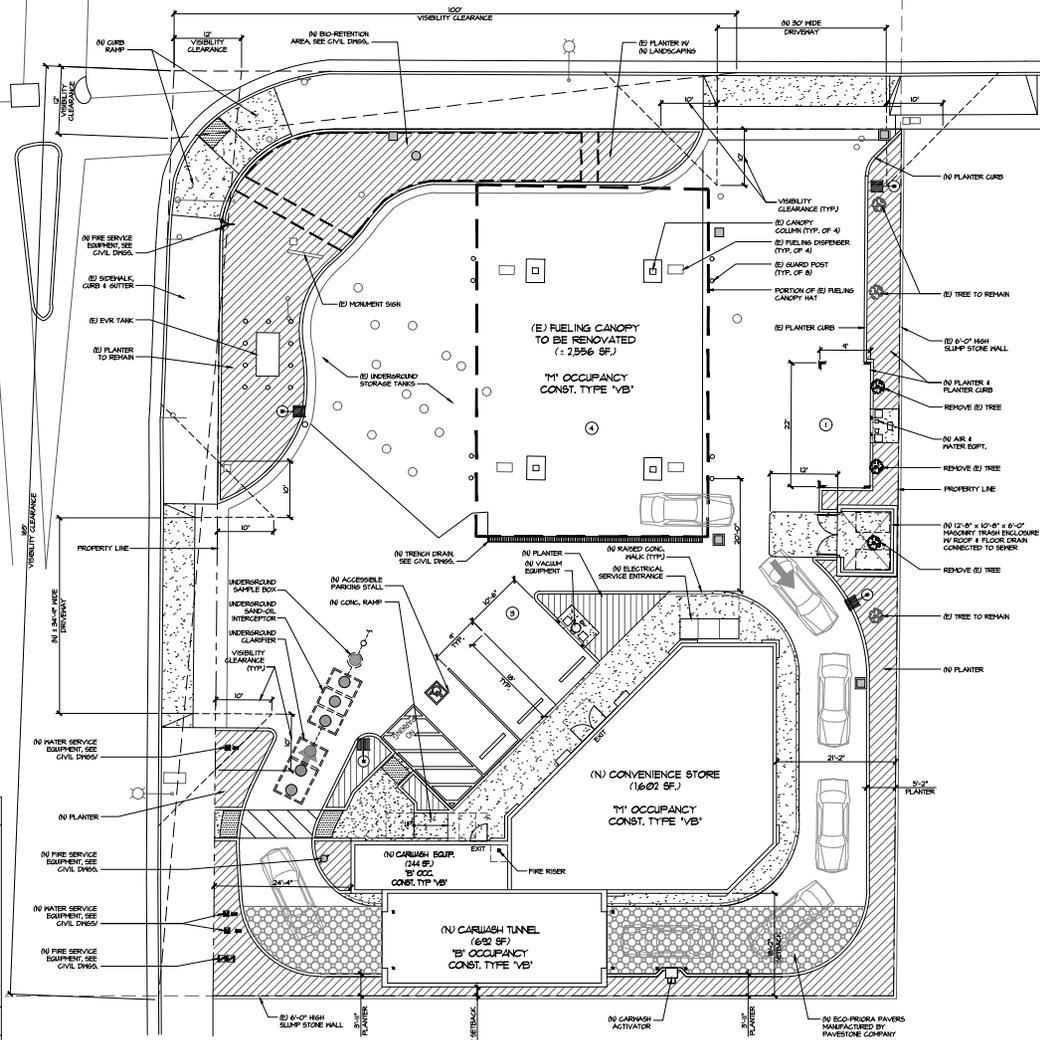**LAWRENCE EXPRESSWAY**



**NOTE:**  
 PER THE ENVIRONMENTAL NOISE ASSESSMENT, PREPARED BY BOLLARD ACOUSTICAL CONSULTANTS, INC., DATED FEBRUARY 6, 2023 THE BOLLARD (RED) IS SOFTGLASS (S) ON BOARD DRY. THE MITIGATION MEASURE REQUIRED (S) IS OF THE INTERIOR WALLS & CEILING OF THE CARWASH TUNNEL TO BE LINED W/ SOUND ABSORPTIVE MATERIAL, AS INDICATED IN THE AFOREMENTIONED ENVIRONMENTAL NOISE ASSESSMENT.

**CODE ANALYSIS**

CONVENIENCE STORE (SPRINKLED): M OCCUPANCY, TYPE V-B  
 CARWASH TUNNEL, CARWASH EQUIP. (SPRINKLED): B OCCUPANCY, TYPE V-B  
 FUEL CANOPY (NON-SPRINKLED): M OCCUPANCY, TYPE V-B  
 FIRE SPRINKLER PROTECTION & SPRINKLER MONITORING FIRE ALARM SYSTEM IS REQUIRED

**APPLICABLE CODES**

CBC 2022  
 CMC 2022  
 CPC 2022  
 CEC 2022  
 CFC 2022

CA. GREEN BUILDING STANDARDS CODE (CALGREEN) 2022  
 CA. ENERGY CODE 2022  
 CALIFORNIA CODE OF REGULATIONS, TITLE 19 CALIFORNIA CODE OF REGULATIONS, TITLE 23  
 2010 ADAAG  
 CITY OF SANTA CLARA MUNICIPAL CODE

 
**OCCUPANCY & EXIT CALCULATIONS**

CONVENIENCE STORE	SALES AREA:	1,020 SF. / 60 +	17 OCCUPANTS
STORAGE/UTILITY/OTHER:	431 SF. / 300 +	2 OCCUPANTS	
WALK-IN COOLER & FREEZER:	198 SF.	0 OCCUPANT	
<b>CARWASH BUILDINGS</b>			
CARWASH TUNNEL:	642 SF. +	0 OCCUPANT	
CARWASH EQUIPMENT:	244 SF. / 300 +	1 OCCUPANT	
<b>TOTAL OCCUPANTS:</b>			<b>20 OCCUPANTS / 41</b>
<b>TOTAL EXITS REQUIRED:</b>			<b>20 OCCUPANTS / 41</b>
<b>TOTAL EXITS PROVIDED:</b>			


**OCCUPANCY CALCULATIONS (TABLE 504.3, 504.4 & 506.2)**

OCCUPANCY	AREA OCCUPANT SQ. FT.	FIRE SPRINKLERS (TYPE V-B)	ALLOWABLE AREA	# OF STORES	HEIGHT	ALLOWABLE AREA RATIO	BUILDING HEIGHT
CARWASH BUILDING 'B'	436	YES	436 / 36,000	1	40 FT.	0.226	17'-6"
FOOD MART 'M'	1556	YES	1556 / 36,000	1		0.043	20'-0"
CANOPY	2556	NO	2556 / 10,000	1		0.26	16'-4 1/2"
<b>TOTAL</b>	<b>5,050</b>					<b>0.344</b>	<b>(OK)</b>

**1 SITE PLAN**  
 SCALE: 1" = 10'-0"



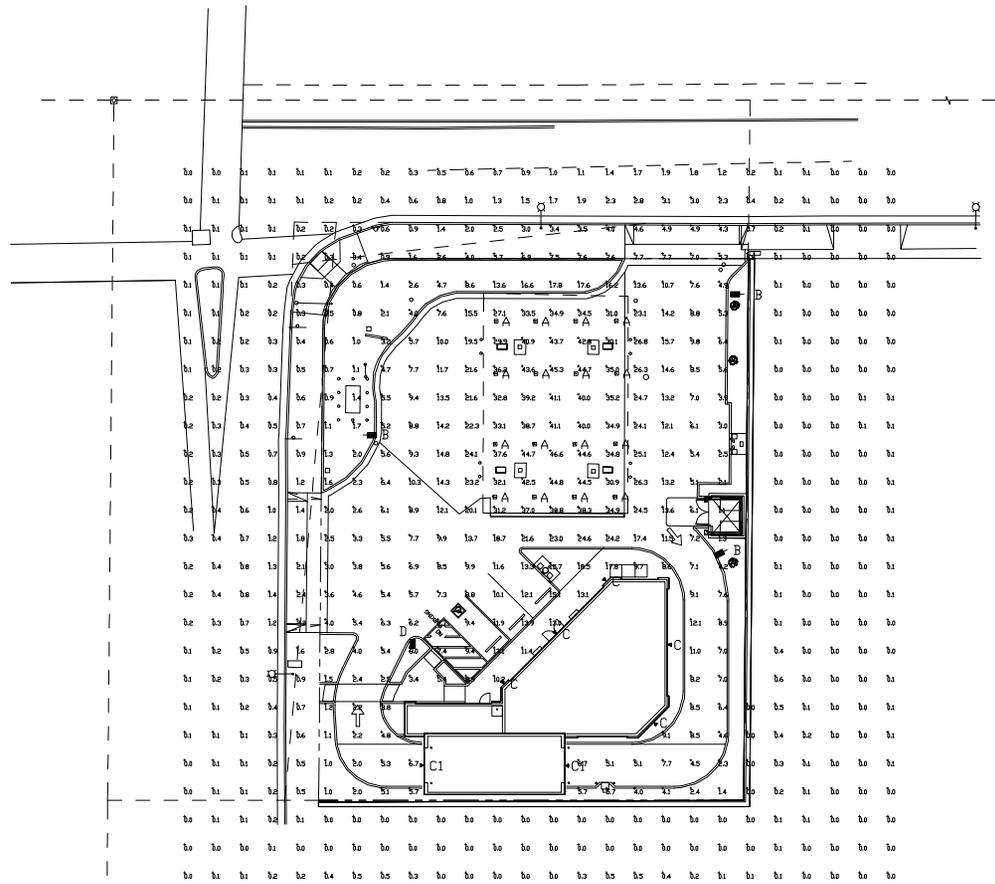SITE PLAN CONFORMS TO FIRE DEPARTMENT STANDARD CONDITIONS



Label	CalcType	Units	Avg	Max	Min	Avg/Min	Max/Min
ALL CALC POINTS	Illuminance	Fc	5.68	46.6	0.0	N/A	N/A
CANOPY	Illuminance	Fc	37.82	46.6	27.1	1.40	1.72
CAR WASH LANE	Illuminance	Fc	7.22	12.1	2.3	3.14	5.26
INSIDE CURB	Illuminance	Fc	11.24	26.8	2.1	5.35	12.76

Symbol	Qty	Label	Arrangement	Description	Mounting Height	LLD	LLF	Arr. Lum. Lumens	Arr. Watts
□	16	A	Single	CRUS-SC-SS-50-DIMMED TO 70%	14'-6"	1000	0.700	13980	93
■	3	B	Single	SLM-LED-18L-SIL-4-50-IL-70CRI-SINGLE	18" POLE +2" BASE	1000	1.000	12011	135
◀	5	C	Single	XWM-FT-LED-06L-50	10'-6"	1000	1.000	6557	47
▶	2	C1	Single	XWM-FT-LED-06L-50	11'-3"	1000	1.000	6557	47
■	1	D	Single	SLM-LED-18L-SIL-4-50-70CRI-SINGLE	18" POLE +2" BASE	1000	1.000	18506	135

**PHOTOMETRIC EVALUATION  
NOT FOR CONSTRUCTION**

Based on the information provided, all dimensions and luminaire locations shown represent recommended positions. The engineer and/or architect must determine the applicability of the layout to existing or future field conditions. This lighting plan represents illumination levels calculated from laboratory data taken under controlled conditions in accordance with the Illuminating Engineering Society (IES) approved methods. Actual performance of any manufacturer's luminaires may vary due to changes in electrical voltage, tolerance in lamp/LED's and other variable field conditions. Calculations do not include obstructions such as buildings, curbs, landscaping, or any other architectural elements unless noted. Fixture nomenclature notes does not include mounting hardware or poles. This drawing is for photometric evaluation purposes only and should not be used as a construction document or as a final document for ordering product.

Total Project Watts  
Total Watts = 2207

**SD1-L**



LIGHTING PROPOSAL LD-158610-4A

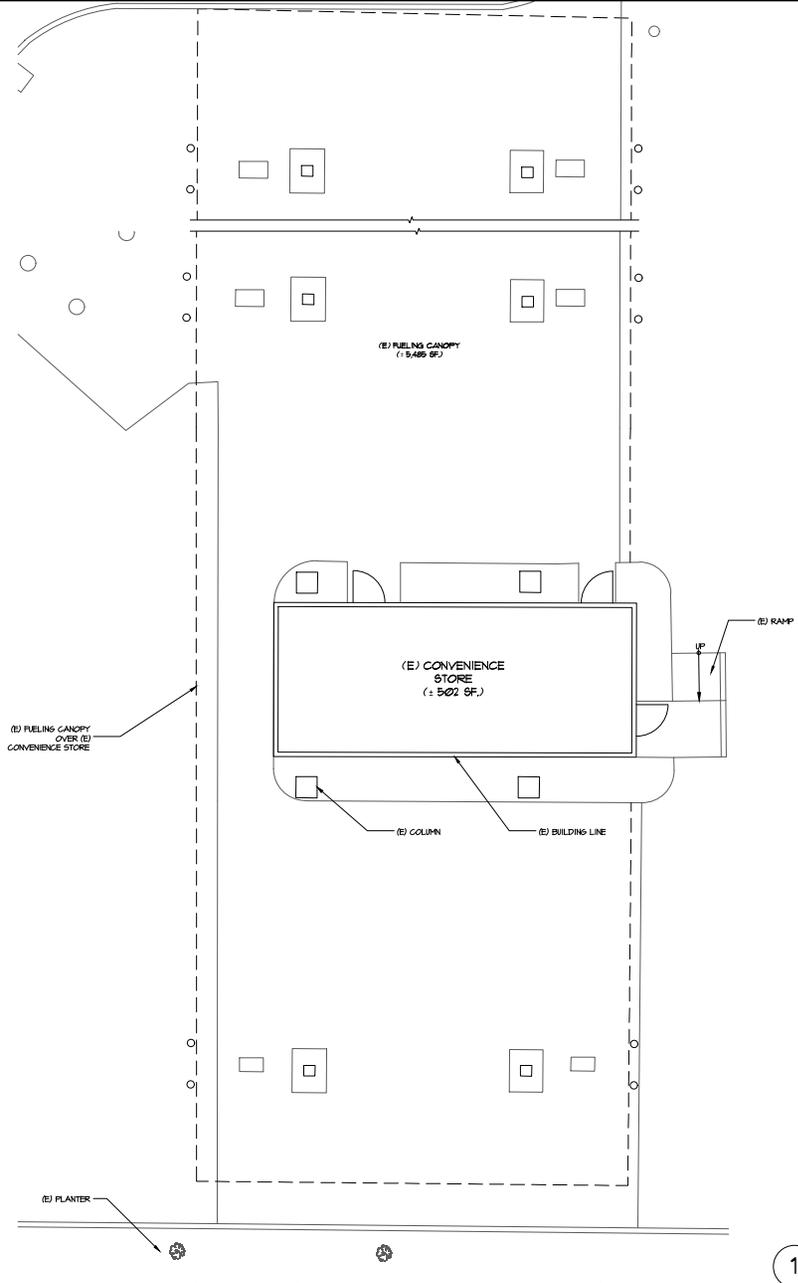
C-STORE  
SIDE LANEWAY EXPRESSWAY  
SANTA CLARITA

DATE: 11/08/22 REVISED: SHEET 1 OF 1


SCALE: 1"=16' 0 16



S:\Projects\22-1450-2455 Lammess Exp. Sump Over\Drawings\22-1450-11.2.dwg modified by mbaron on 4/8/22 2:05:48 PM



 **1** EXISTING FLOOR PLAN  
SCALE: 3/16" = 1'-0"



M Architects, Inc.  
ARCHITECTURE  
PLANNING  
MANAGEMENT  
DESIGN  
1801 OAKLAND BLVD  
SUITE 300  
WALNUT CREEK, CA  
94596  
925-287-1174 Tel  
925-443-1591 Fax  
925-678-9875 Cell  
mthano@marchitect.com  
www.marchitect.com

NOT FOR  
CONSTRUCTION

CONVENIENCE STORE & CARWASH  
2455 LAWRENCE EXPRESSWAY  
SANTA CLARA, CA 95051

DRAWINGS AND SPECIFICATIONS AND THE CONTENTS THEREOF CONSTITUTE THE ORIGINAL UNPUBLISHED WORK OF M.A. ARCHITECTS, INC. ANY REPRODUCTION OR TRANSMISSION OF THIS DOCUMENT WITHOUT WRITTEN CONSENT FROM M.A. ARCHITECTS, INC. IS PROHIBITED.


-	ISSUED FOR CONSTRUCTION	
-	ISSUED FOR PLAN CHECK	
-	ISSUED FOR PLANNING	
NO.	DATE	DESCRIPTION
△		
△		
△		
△		

EXISTING FLOOR PLAN


PROJECT #	22-14501
DRAWN BY	EG
CHECKED BY	MH
SCALE AS NOTED	DATE: 10-10-22

**A1.0**  
SHEET OF

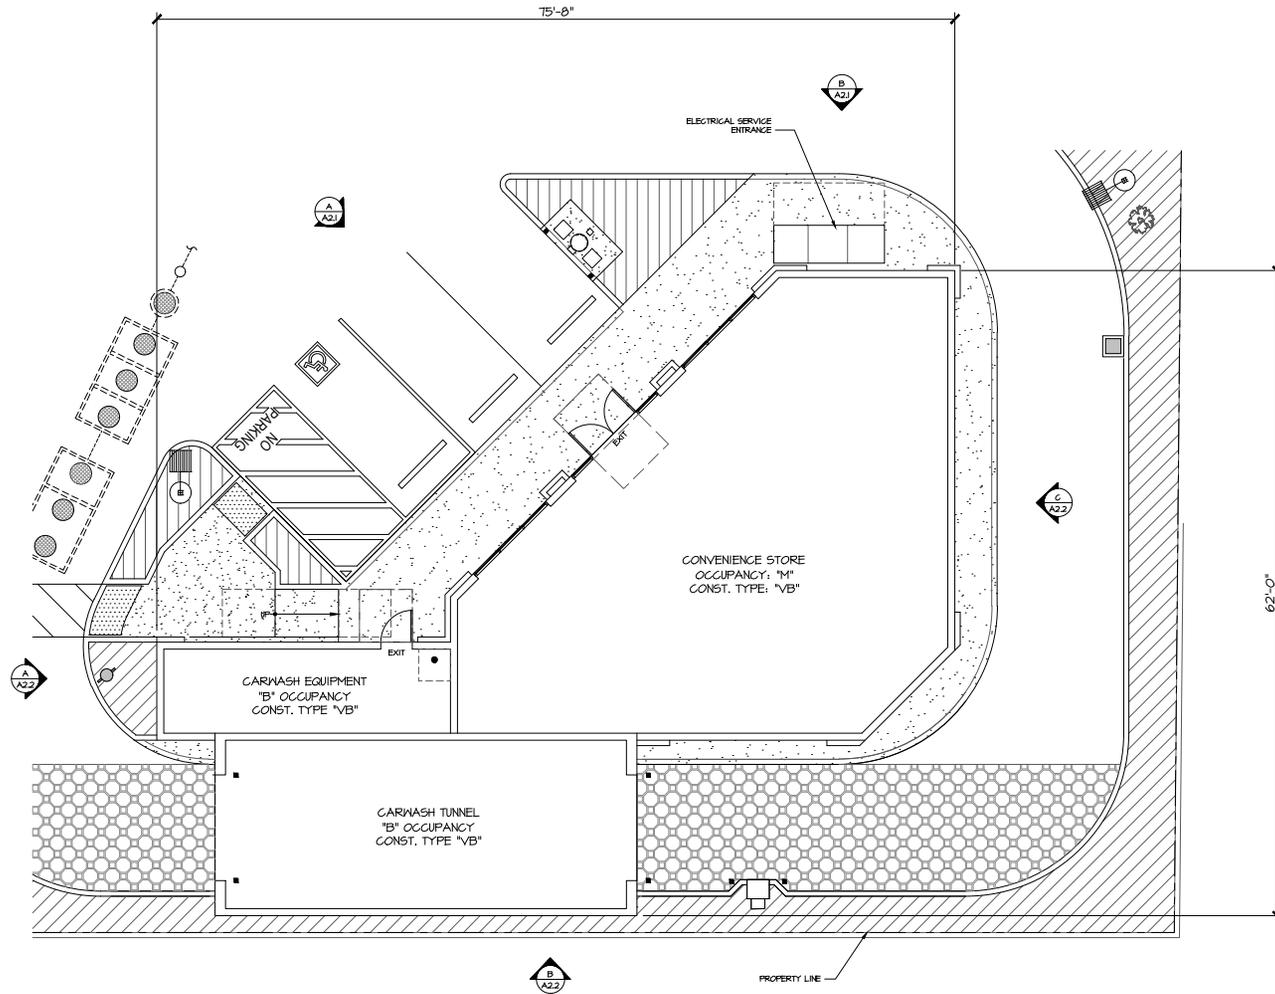S:\Projects\22-4401-2455-2456-2458-2459-2460-2999-3000



 **1 PROPOSED FLOOR PLAN**  
SCALE: 3/16" = 1'-0"



**M I Architects, Inc.**  
ARCHITECTURE  
PLANNING  
MANAGEMENT  
DESIGN  
1801 OAKLAND BLVD  
SUITE 300  
WALNUT CREEK, CA  
94596  
925-287-1174 Tel  
925-443-1501 Fax  
925-678-9875 Cell  
mihon@miaarchitect.com  
www.miaarchitect.com

NOT FOR  
CONSTRUCTION

**CONVENIENCE STORE & CARWASH  
2455 LAWRENCE EXPRESSWAY  
SANTA CLARA, CA 95051**

DRAWINGS AND SPECIFICATIONS AND THE CONTENTS HEREOF ARE THE ORIGINAL UNREVISED WORK OF M I ARCHITECTS, INC. ANY REVISIONS OR CHANGES TO THESE DRAWINGS SHALL BE MADE BY M I ARCHITECTS, INC. THE REPLICATION OR DISSEMINATION OF THESE DRAWINGS WITHOUT WRITTEN CONSENT FROM M I ARCHITECTS, INC. IS PROHIBITED.

- ISSUED FOR CONSTRUCTION
- ISSUED FOR PLAN CHECK
- ISSUED FOR PLANNING

NO.	DATE	DESCRIPTION

PROPOSED FLOOR PLAN

PROJECT #: 22-14501  
DRAWN BY:                      CHECKED: MII  
SCALE: AS NOTED    DATE: 10-10-22


**A1.1**

SHEET                      OF


NOT FOR CONSTRUCTION

CONVENIENCE STORE & CARNASH  
 2455 LAWRENCE EXPRESSWAY  
 SANTA CLARA, CA 95051


DRAWINGS AND SPECIFICATIONS AND THE CONCEPTS ILLUSTRATED ARE THE ORIGINAL UNREVISED WORK OF M ARCHITECTS, INC. ANY REVISIONS OR CHANGES TO THESE DRAWINGS SHALL BE MADE BY M ARCHITECTS, INC. IN WRITING. THE REPLICATION OR DISSEMINATION OF THESE DRAWINGS WITHOUT EXPRESS WRITTEN CONSENT FROM M ARCHITECTS, INC. IS PROHIBITED.

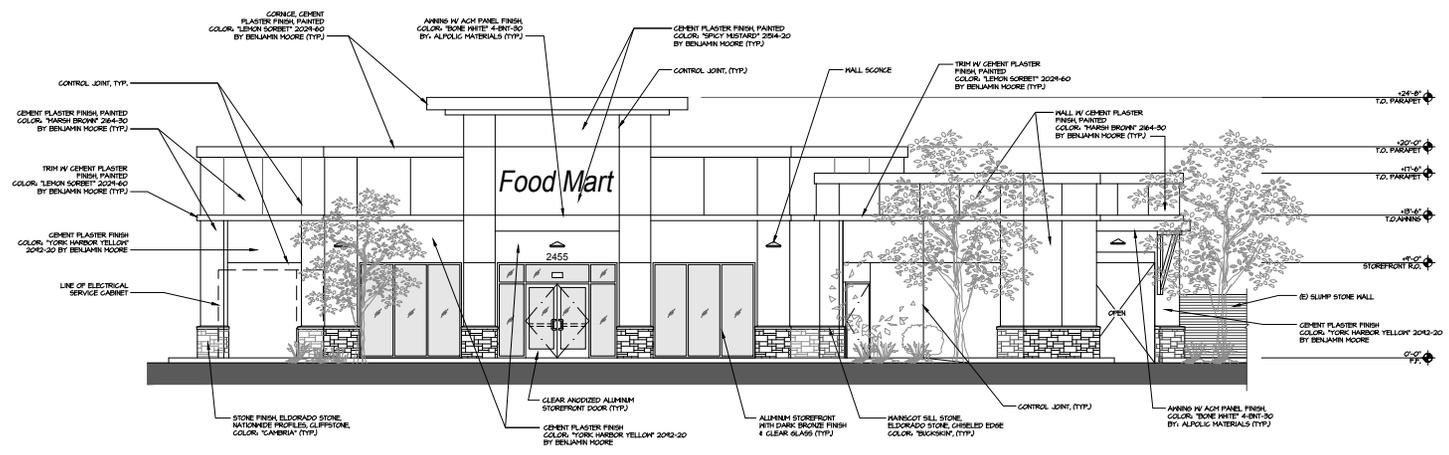

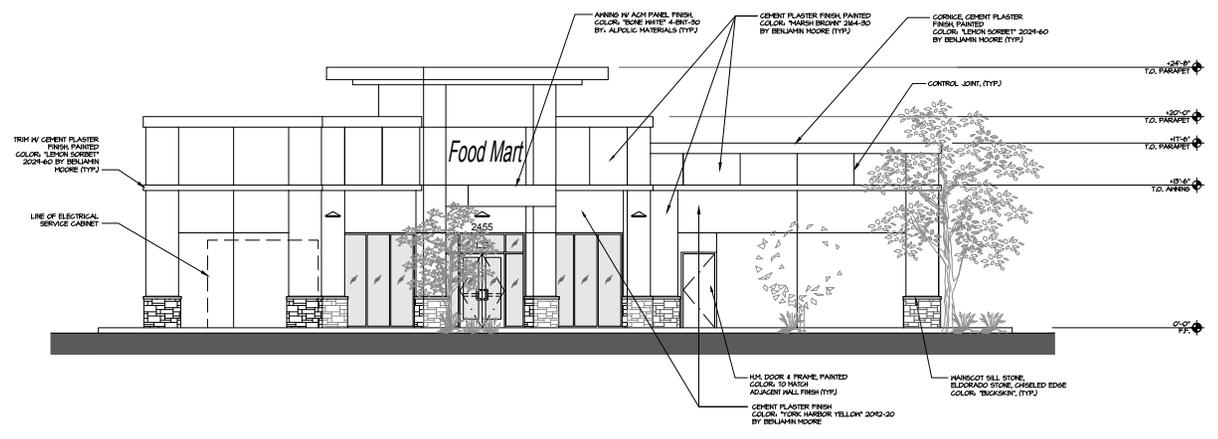**A** NORTHWEST ELEVATION  
 3/16" = 1'-0"



**B** NORTH ELEVATION  
 3/16" = 1'-0"

 

-	ISSUED FOR CONSTRUCTION	
-	ISSUED FOR PLAN CHECK	
-	ISSUED FOR PLANNING	
NO.	DATE	DESCRIPTION
△		
△		
△		


EXTERIOR ELEVATIONS

PROJECT #:	22-14501
DRAWN BY:	emg
CHECKED BY:	mll
SCALE AS NOTED:	DATE: 10-10-22


S:\Projects\22-14501-14501-2455 Lawrence Exp. Store\Drawings\Exterior\22-14501-401 & 402.dwg modified by mthoan on Feb 11, 2023 - 1:29pm



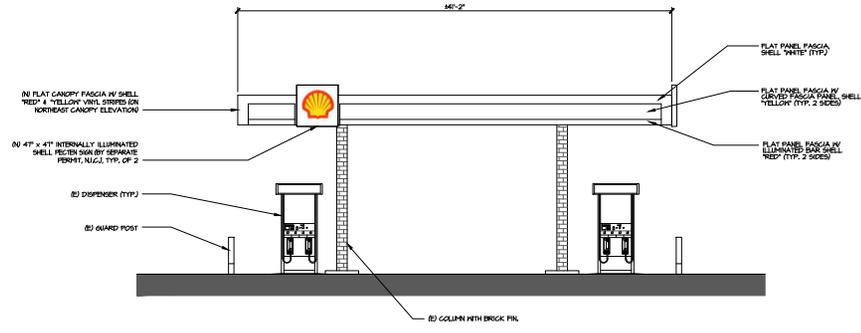S:\Projects\22-14501-2455 Lawrence Exp. S&B Drawings\Drawings\22-14501-CA1.dwg modified at Feb. 12, 2025 - 8:44am



**A NORTH ELEVATION**  
3/16" = 1'-0"

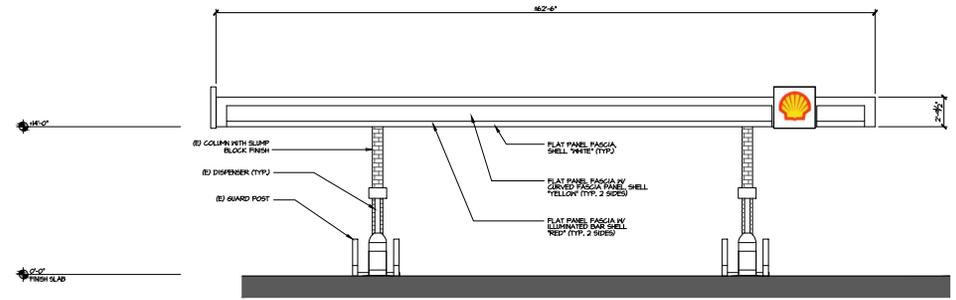

**B WEST ELEVATION**  
3/16" = 1'-0"



**M1 Architects, Inc.**  
ARCHITECTURE  
PLANNING  
MANAGEMENT  
DESIGN  
1801 OAKLAND BLVD  
SUITE 300  
WALNUT CREEK, CA  
94596  
925-287-1174 Tel  
925-443-1591 Fax  
925-678-9875 Cell  
m1hono@m1architect.com  
www.m1architect.com

NOT FOR CONSTRUCTION

**CONVENIENCE STORE & CARWASH**  
**2455 LAWRENCE EXPRESSWAY**  
**SANTA CLARA, CA 95051**

DRAWINGS AND SPECIFICATIONS AND THE CONTENTS THEREOF SHALL BE THE PROPERTY OF M1 ARCHITECTS, INC. NO REPRODUCTION OR DISSEMINATION OF THE CONTENTS WITHOUT EXPRESS WRITTEN CONSENT FROM M1 ARCHITECTS, INC. IS PERMITTED.

-	ISSUED FOR CONSTRUCTION
-	ISSUED FOR PLAN CHECK
-	ISSUED FOR PLANNING

NO.	DATE	DESCRIPTION
△		
△		
△		
△		

CANOPY ELEVATIONS

PROJECT #	22-14501
DRAWN BY	EG
CHECKED BY	MI
SCALE AS NOTED	DATE: 10-10-22

**CA1**

SHEET 01